




1 EAST WALL
Scale: 1:75

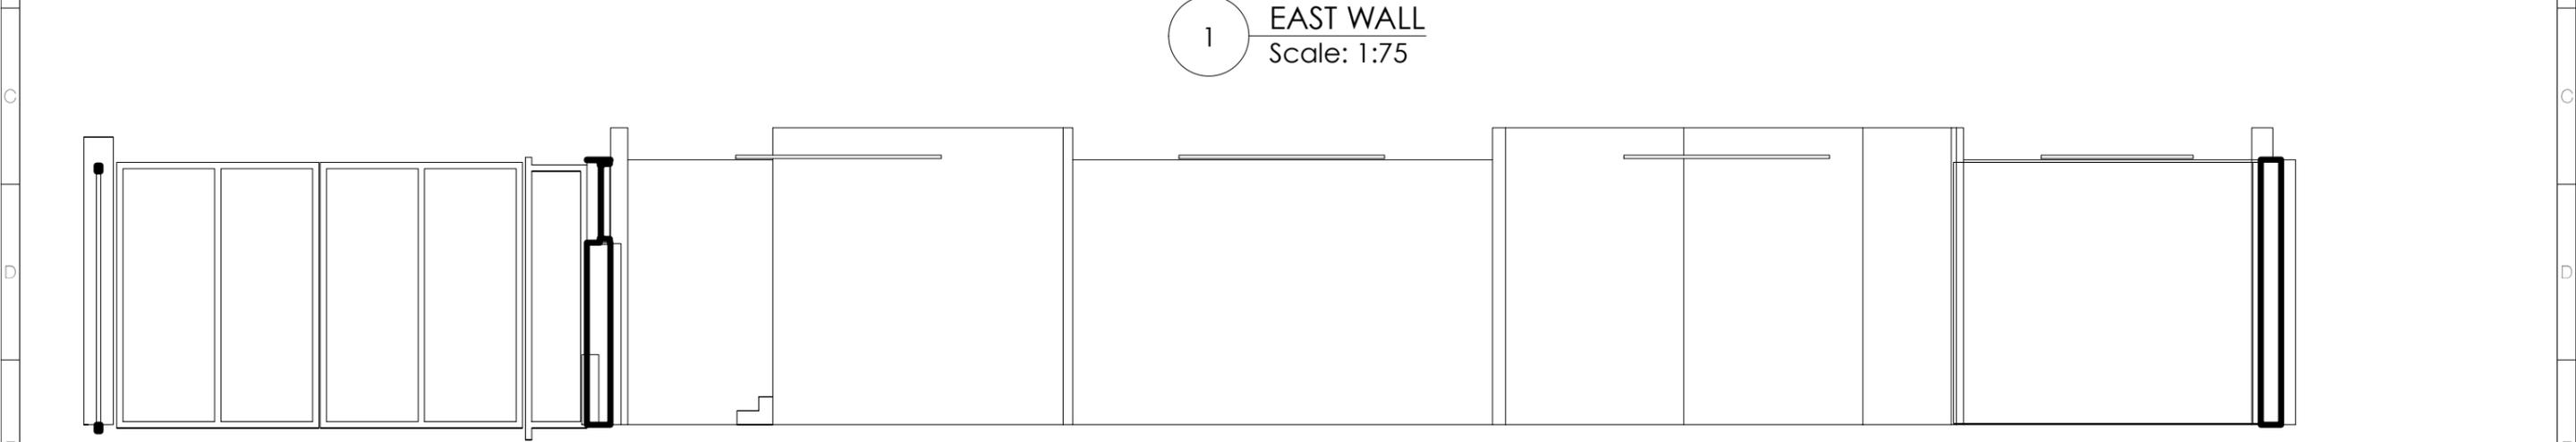

2 WEST WALL
Scale: 1:75

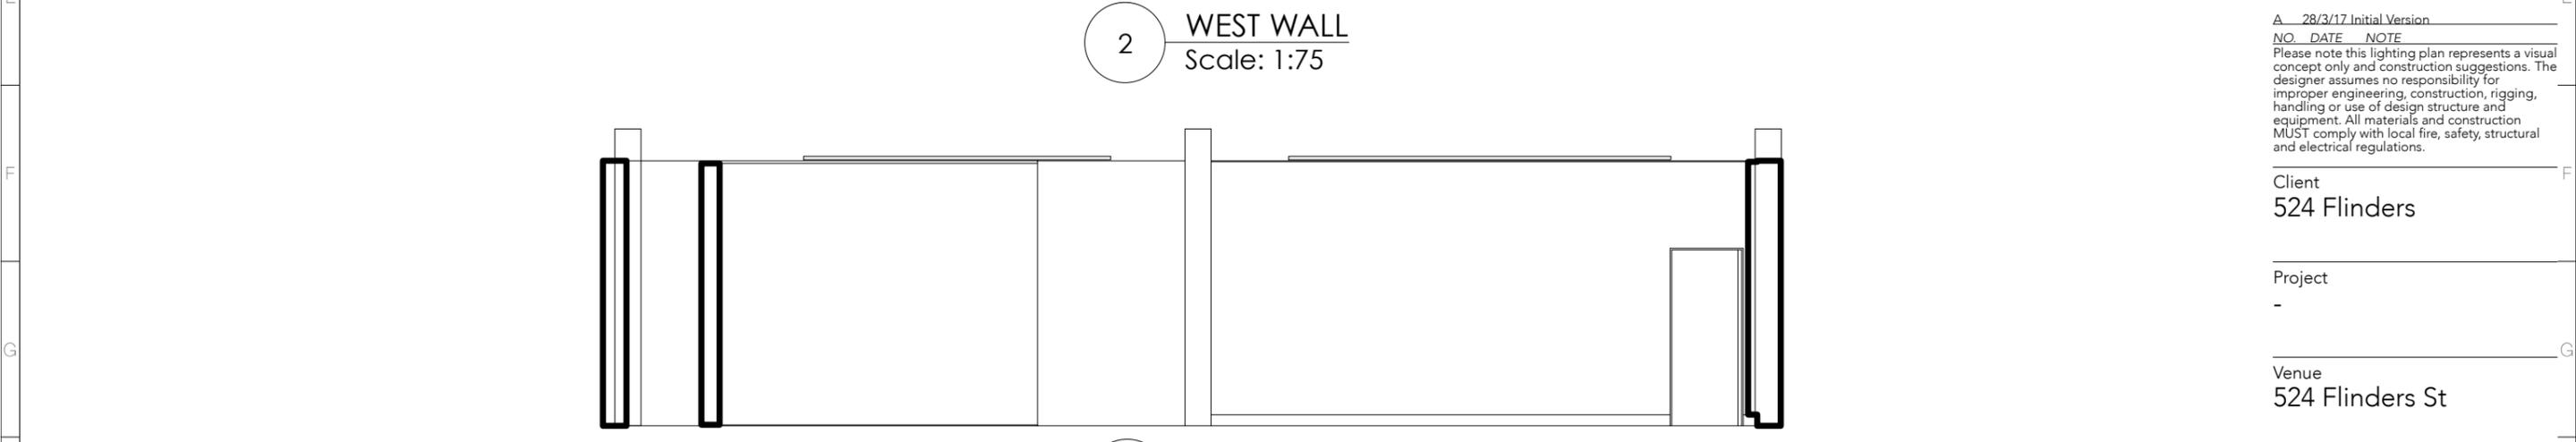

3 NORTH WALL
Scale: 1:75

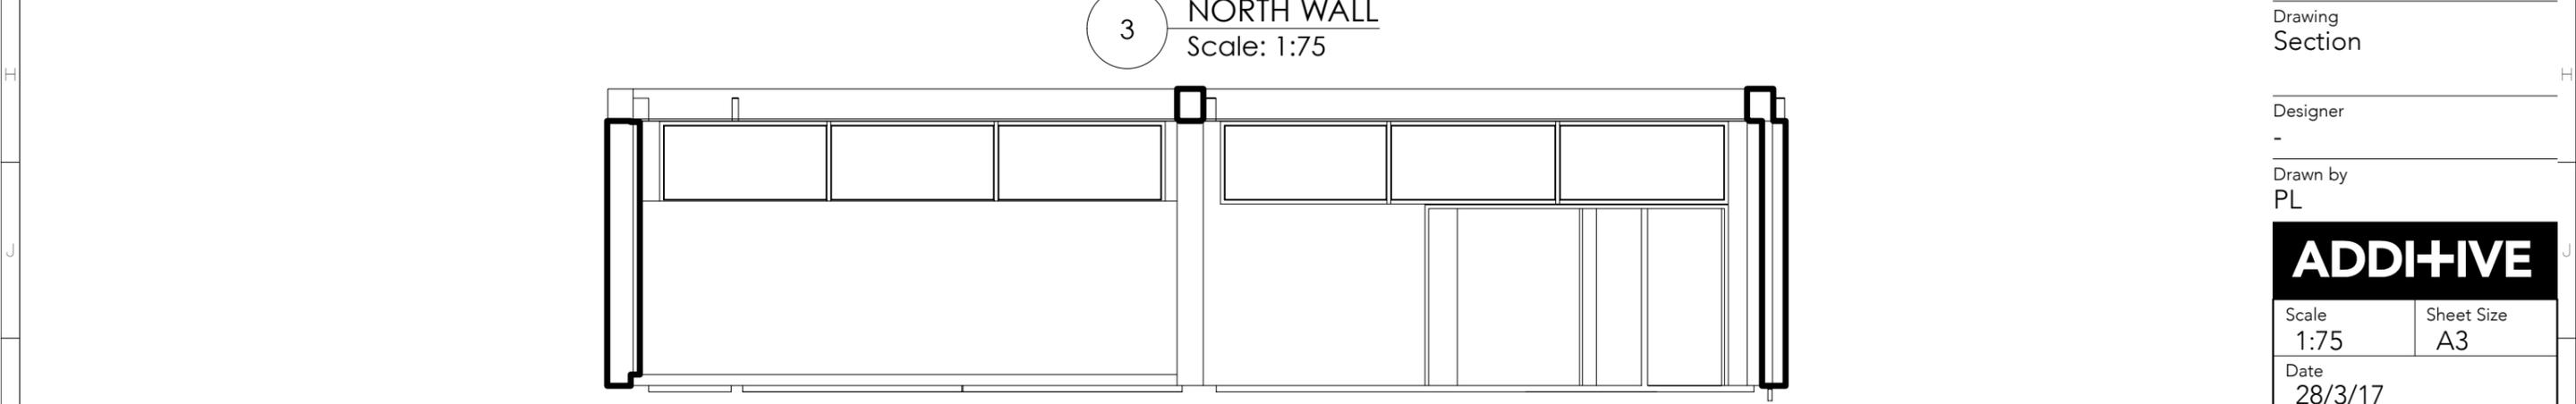

4 SOUTH WALL
Scale: 1:75

A 28/3/17 Initial Version
NO. DATE NOTE
Please note this lighting plan represents a visual concept only and construction suggestions. The designer assumes no responsibility for improper engineering, construction, rigging, handling or use of design structure and equipment. All materials and construction MUST comply with local fire, safety, structural and electrical regulations.

Client
524 Flinders

Project
-

Venue
524 Flinders St

Drawing
Section

Designer
-

Drawn by
PL

| | |
|------------------------|------------------|
| ADDITIVE | |
| Scale 1:75 | Sheet Size A3 |
| Date 28/3/17 | |
| Job No. 524FLINDERS | Dwg No. 100 |
| Rev. A | |